



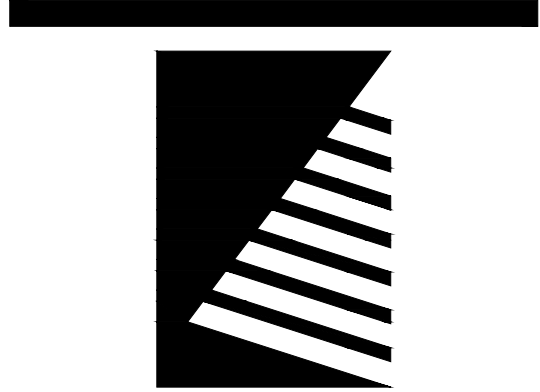


STATISTICS						
DESCRIPTION	SYMBOL	AVG	MAX	MIN	MAX/MIN	AVG/MIN
PARKING	+	1.36 FC	8.1 FC	0.4 FC	20.25	3.4
SIDEWALK	+	6.65 FC	17.2 FC	0.2 FC	86	33.25
FULL SITE	+	1.60 FC	16.7 FC	0.0 FC	N/A	N/A

LUMINAIRE SCHEDULE									
TYPE	MANUFACTURER	LUMINAIRE SERIES	SOURCE (TYPE/COLOR TEMP/CRI)	VOLTAGE	LOAD (VA)	LUMEN OUTPUT	FINISH	MOUNTING	DESCRIPTION
S1	MCGRAW-EDISON	GLEON GALLEON SERIES	LED, 4000K, 70CRI	208V	33	4,617	BRONZE	25'-0" AFG	POLE MOUNTED SITE LUMINAIRE, FULL CUT-OFF, TYPE IV FORWARD THROW DISTRIBUTION, HOUSE SIDE SHIELD, MOTION SENSOR FOR DIMMING OPERATION, HOUSE SIDE SHIELD
S2	MCGRAW-EDISON	GLEON GALLEON SERIES	LED, 4000K, 70CRI	208V	57	7,098	BRONZE	25'-0" AFG	POLE MOUNTED SITE LUMINAIRE, FULL CUT-OFF, TYPE IV FORWARD THROW DISTRIBUTION, HOUSE SIDE SHIELD, MOTION SENSOR FOR DIMMING OPERATION, HOUSE SIDE SHIELD
W1	COOPER	LUMARK SERIES	LED, 4000K, 70CRI	120V	58	6,129	CARBON BRONZE	14'-0" AFG	FULL CUT-OFF WALL PACK WITH PHOTOCELL AND UNOCCUPIED DIMMING TO 50%
W2	COOPER	LUMARK SERIES	LED, 4000K, 70CRI	120V	12	1,418	CARBON BRONZE	9'-0" AFG	FULL CUT-OFF WALL PACK WITH PHOTOCELL AND UNOCCUPIED DIMMING TO 50%
NOTES: A. REMOVE ALL FINGER PRINTS FROM LENSES, REFLECTORS, AND LOUVERS FOLLOWING LIGHT FIXTURE INSTALLATION. B. PROVIDE ALL HOLLOW POLES WITH VIBRATION DAMPERS BY THE FACTORY.									

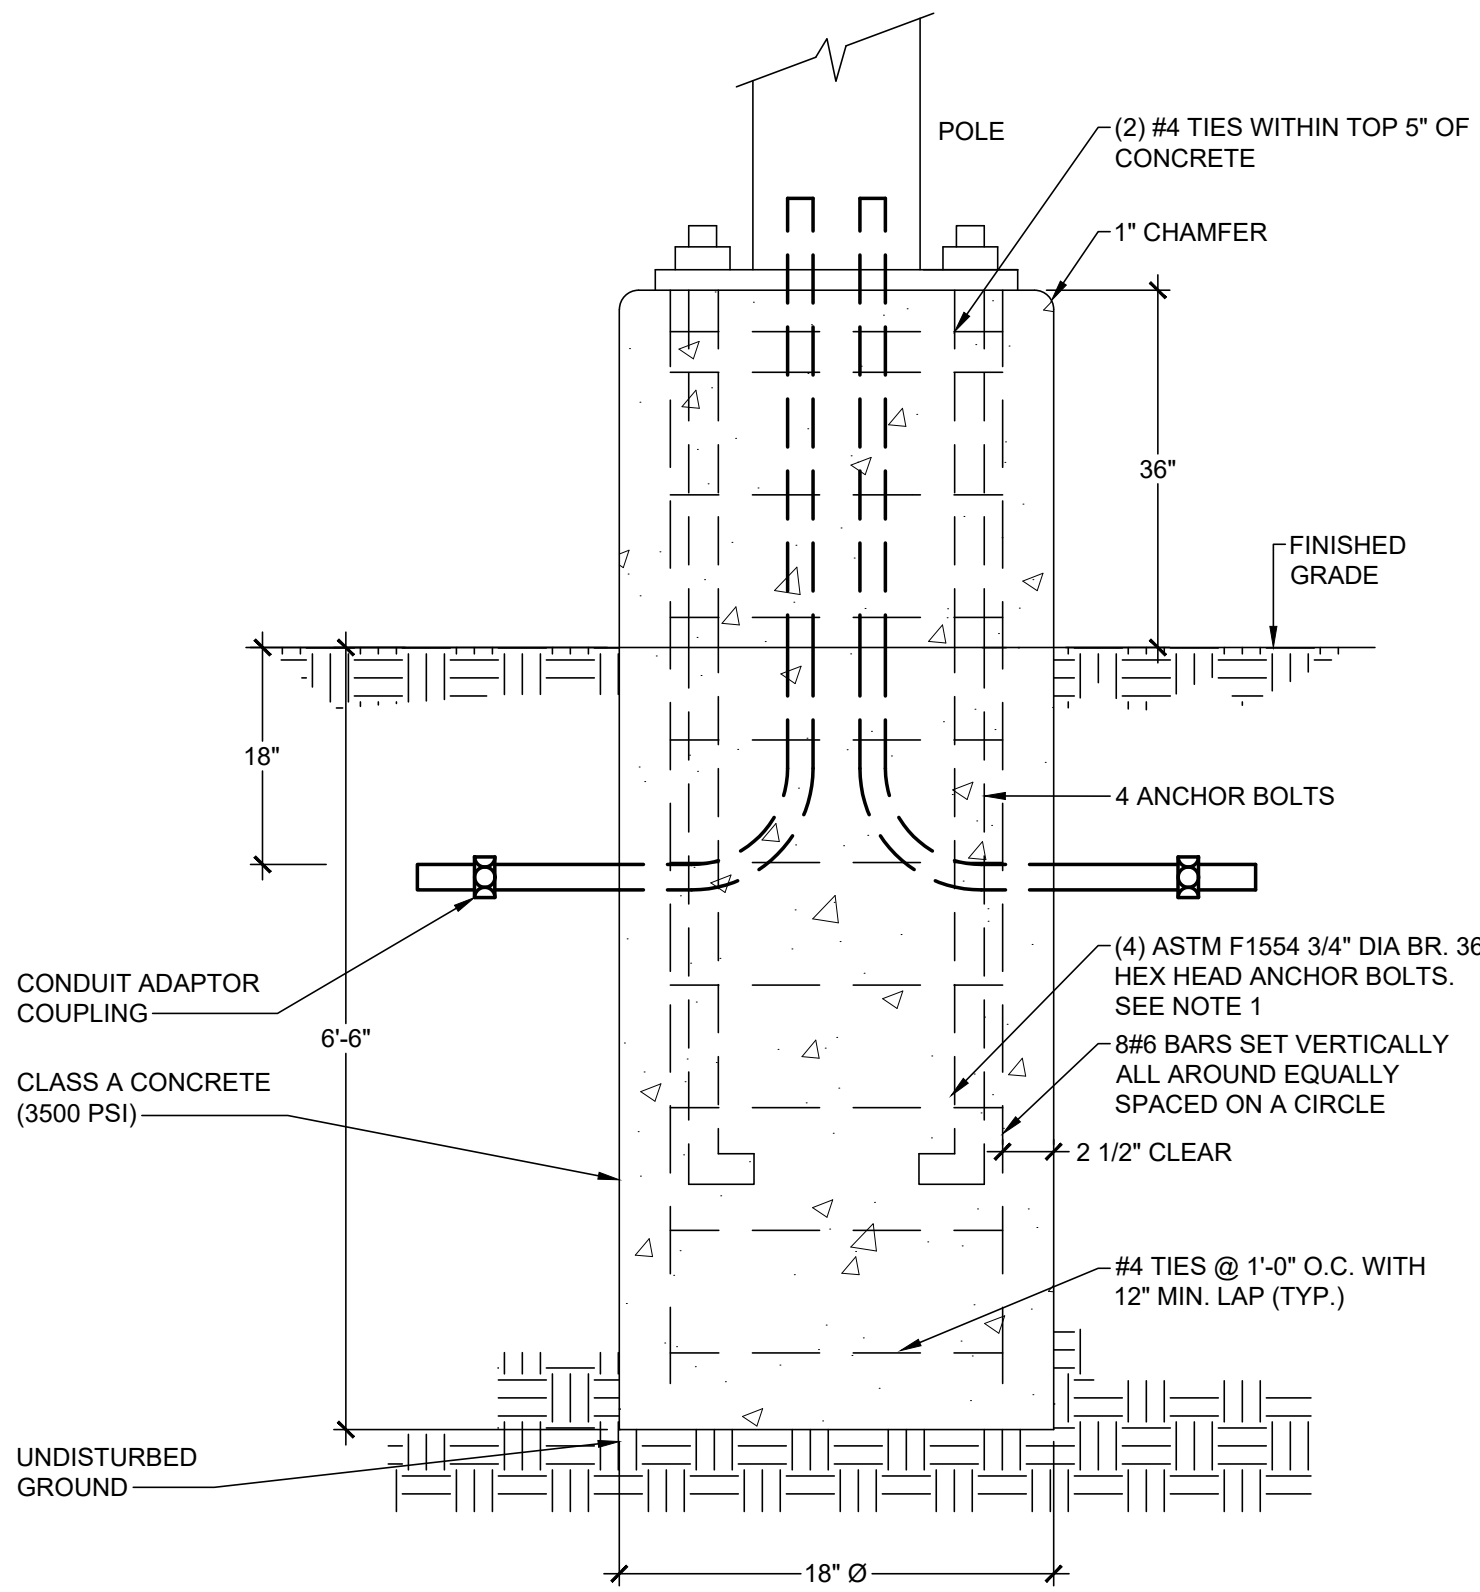

- NOTES:
- IT SHALL BE THE CONTRACTORS RESPONSIBILITY TO CHECK AND VERIFY ALL ANCHOR BOLT DIMENSIONS (SIZE, BOLT CIRCLE, ETC.) WITH THE CONTRACTOR WHO WILL BE INSTALLING THE LIGHTING STANDARD PRIOR TO INSTALLATION OF THE FOUNDATIONS.
 - CHAMFER EXPOSED EDGES OF ALL FOUNDATIONS.
 - PROVIDE INSULATING GROUNDING BUSHING ON EXPOSED ENDS (IN BASE OF POLE) OF ALL GALVANIZED STEEL BENDS.

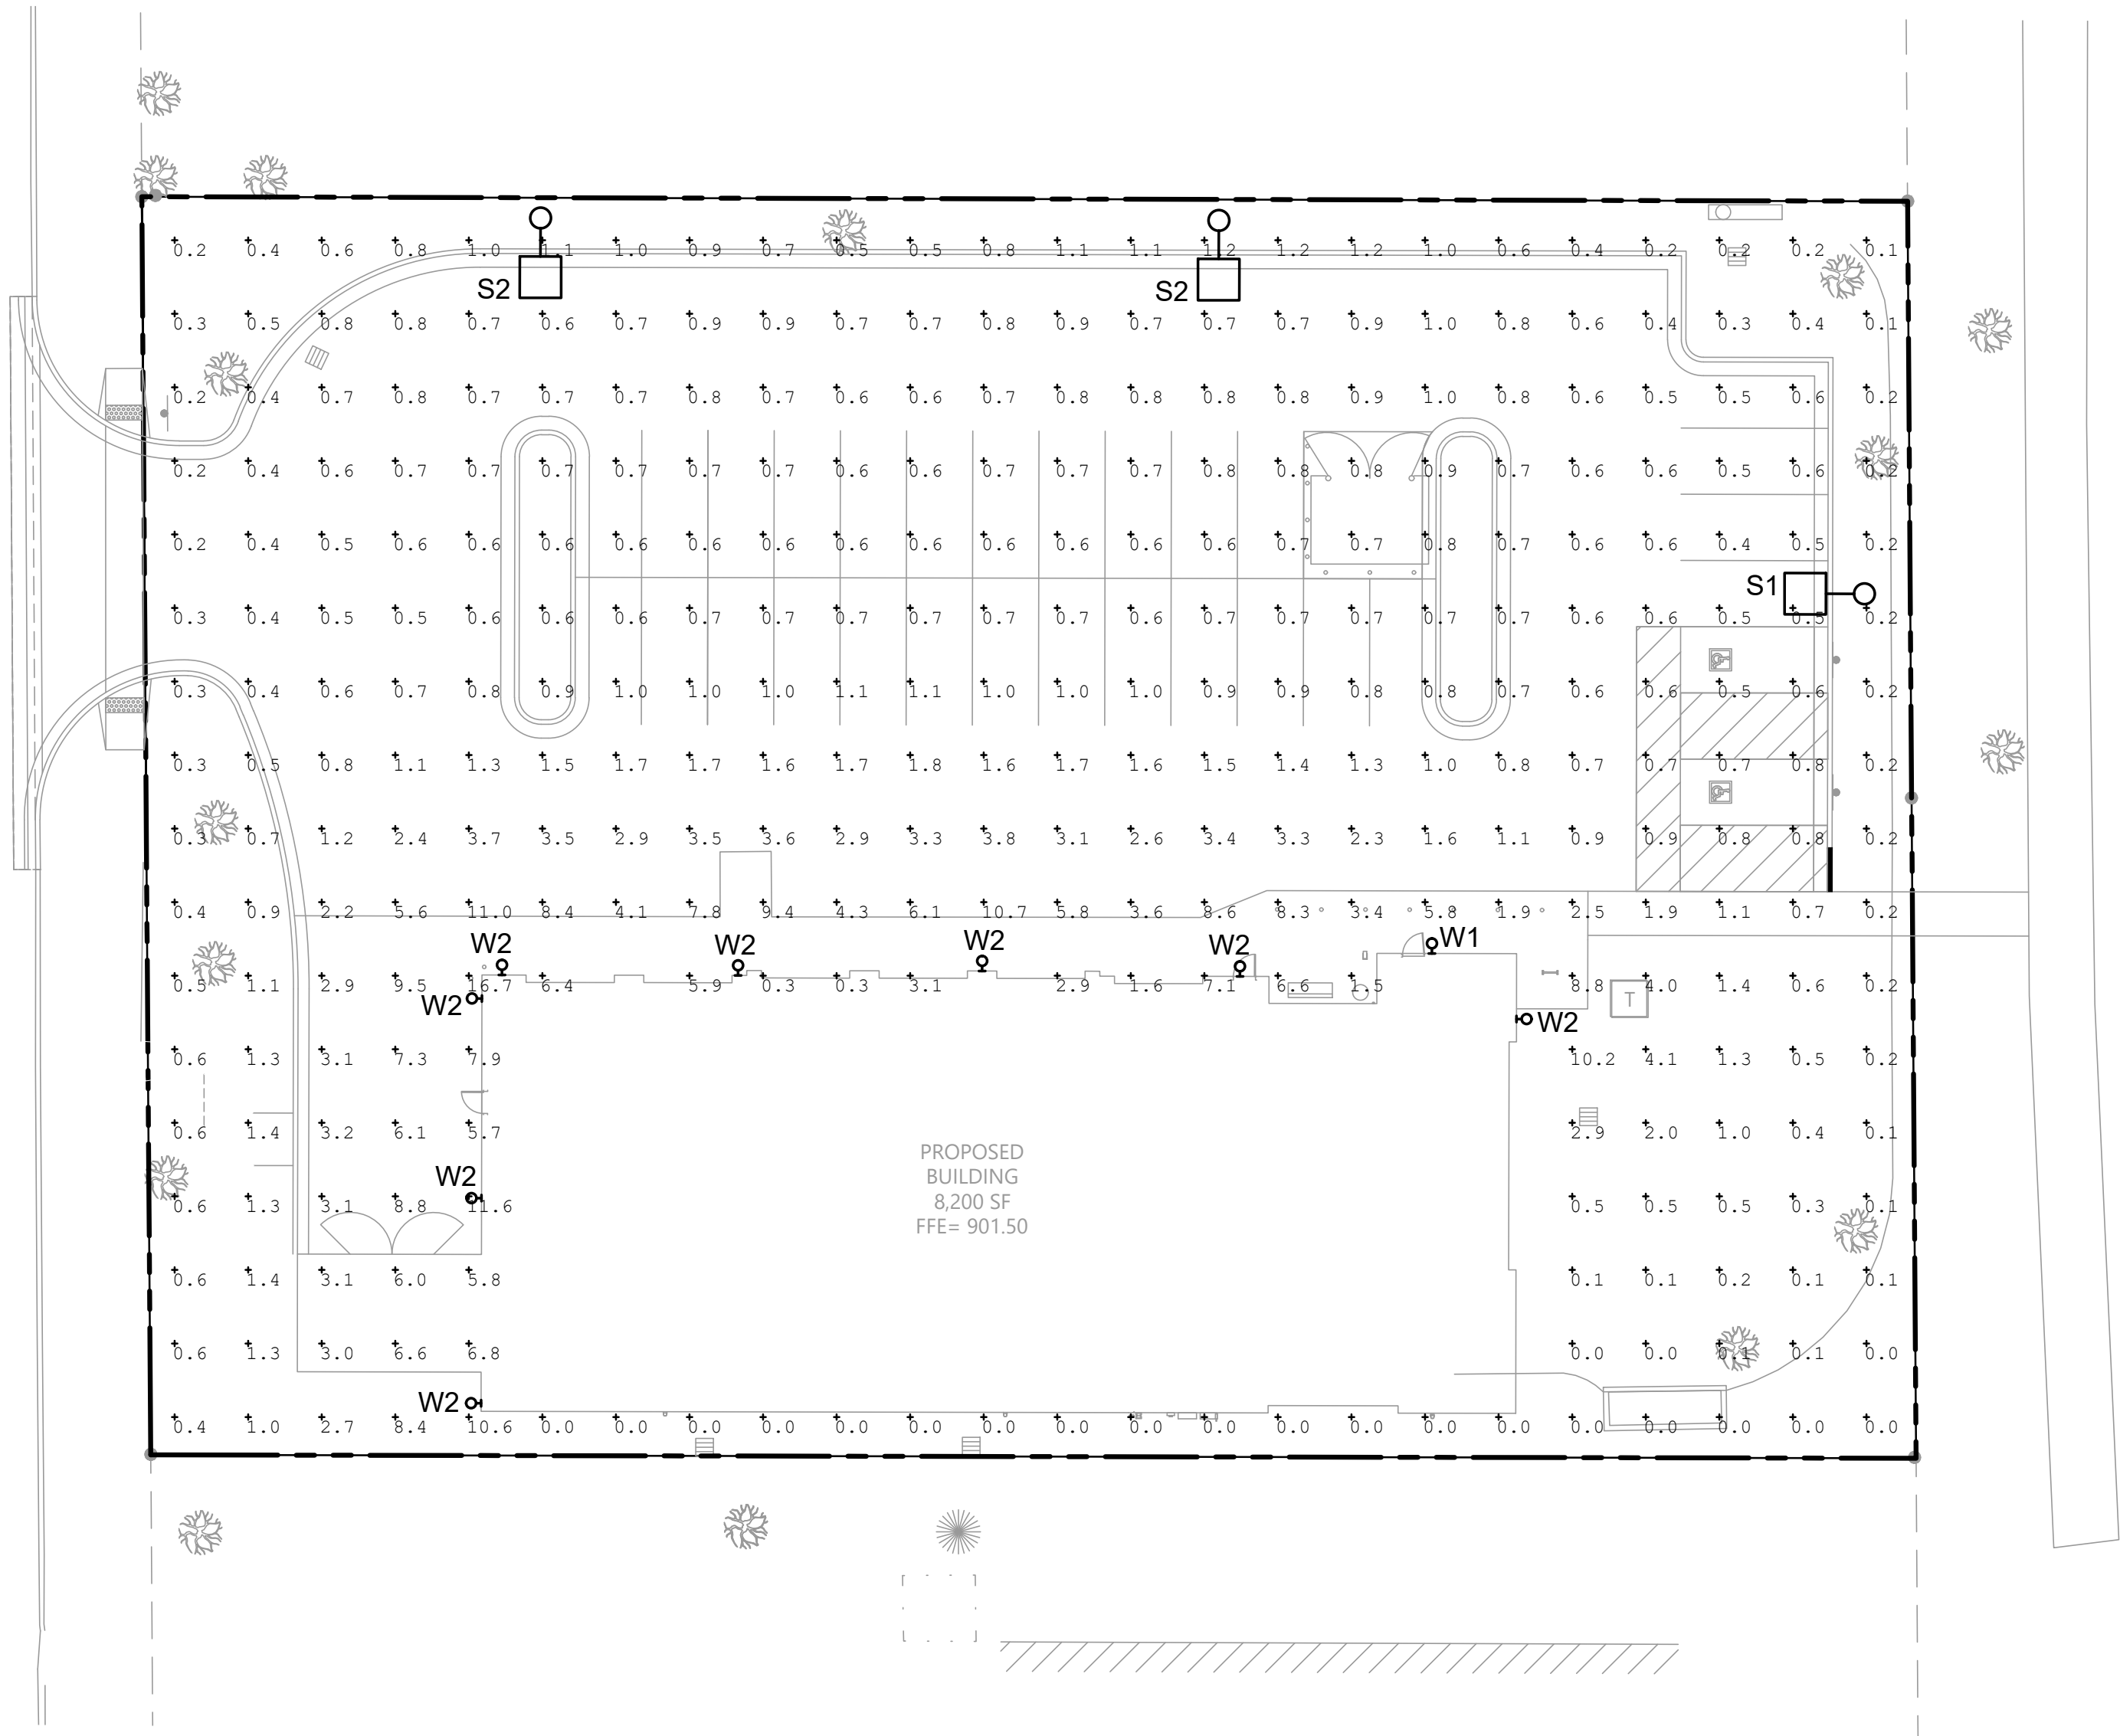

AMES, IOWA
6 BAY STORE

LES SCHWAB TIRE CENTER -
AMES, IA

© 2026 | ALL RIGHTS RESERVED

LES SCHWAB TIRE
CENTER - AMES
SOUTH

03.10.2026
PROJECT# | SS MVP 6R
DESIGNED BY | JPG
DRAWN BY | JPG
REVISIONS

PHOTOMETRIC PLAN



